


# MILES MACK BUILDING RENOVATION

732 N 36th St #66, Philadelphia, PA 19104

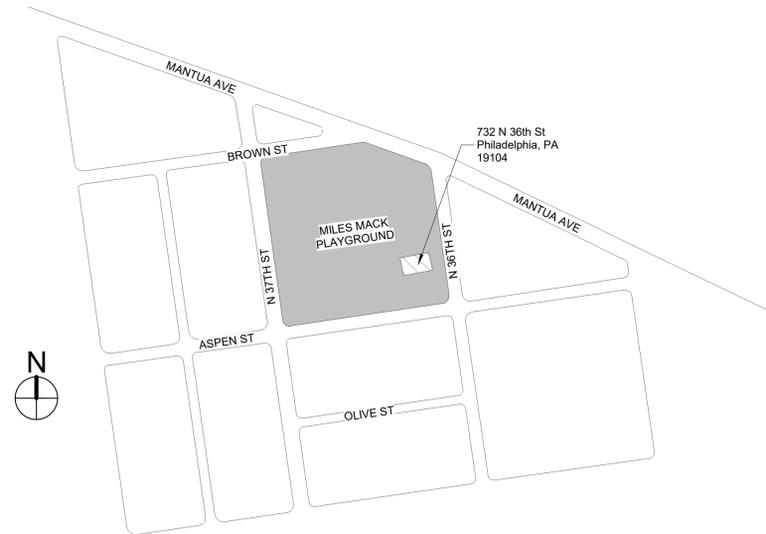

## ARCHITECTURAL & SYSTEMS

Addendum #3  
- 3/9/20

SHEET NUMBER	SHEET NAME
G0.0	COVER SHEET
G0.1	REFERENCE PLAN
G0.2	SYMBOLS & ABBREVIATIONS
G0.3	LIFE SAFETY PLAN & CODE ANALYSIS
S1.1	STRUCTURAL PLANS
S5.1	CONCRETE DETAILS & NOTES
S5.2	CMU DETAILS
S5.3	STEEL DETAILS
A1.0	DEMOLITION PLANS
A1.1	DEMOLITION RCP
A1.2	DEMOLITION ELEVATIONS
A2.0	FLOOR PLAN AND WALL TYPES
A2.1	ROOF PLAN & DETAILS
A3.0	REFLECTED CEILING PLANS
A4.0	EXTERIOR ELEVATIONS
A4.1	ILLUSTRATIVE EXTERIOR ELEVATIONS
A5.0	WALL SECTIONS & DETAILS
A5.1	MISCELLANEOUS DETAILS
A6.0	ENLARGED KITCHENETTE PLAN AND DETAILS
A6.1	ENLARGED FLOOR PLANS & ELEVATIONS
A7.0	DOOR, WINDOW, EQUIPMENT & TOILET ACCESSORIES SCHEDULES
A8.0	FINISH PLAN & SCHEDULE
M0.01	SYMBOLS, NOTES, DETAILS & ABBREVIATIONS
MD1.01	FLOOR PLAN - MECHANICAL DEMOLITION
M1.01	FLOOR PLAN - MECHANICAL
M1.02	ROOF PLAN - MECHANICAL
M6.01	SCHEDULES - MECHANICAL
M7.01	CONTROLS - MECHANICAL
P0.01	SYMBOLS, NOTES, SCHEDULES, DETAILS, & ABBREVIATIONS
PD1.01	FLOOR PLAN - PLUMBING DEMOLITION
P1.01	FOUNDATION PLAN - PLUMBING
P1.02	FLOOR PLAN - PLUMBING
P1.03	ROOF PLAN - PLUMBING
E0.01	SYMBOLS, SCHEDULES, NOTES, AND ABBREVIATIONS
E1.01	FLOOR PLAN ELECTRICAL DEMOLITION
E2.01	FLOOR PLAN - ELECTRICAL
E2.02	FLOOR PLAN - ELECTRICAL
E2.03	FLOOR PLAN - ELECTRICAL
E2.04	FLOOR PLAN - ELECTRICAL
E3.01	PANEL SCHEDULES & ONE-LINE DIAGRAMS

REVISIONS		
ISSUE	DATE	DESCRIPTION
1	3/6/20	Addendum #2
2	3/9/20	Addendum #3



**PROJECT COORDINATOR**  
Philadelphia Parks & Recreation  
and Department of Public Property  
1515 Arch Street, 11th Floor  
Philadelphia, PA 19102  
Contact: Charles Motterhead, 215.683-4466



**PROJECT TEAM**

**ARCHITECT:**  
JOHNSON, MIRMIRAN & THOMPSON, INC  
1600 MARKET ST, SUITE 520  
PHILADELPHIA, PA 19103  
267.256.0300

**STRUCTURAL ENGINEER:**  
JOHNSON, MIRMIRAN & THOMPSON, INC  
1600 MARKET ST, SUITE 520  
PHILADELPHIA, PA 19103  
267.256.0300

**SYSTEMS ENGINEER:**  
JOHNSON, MIRMIRAN & THOMPSON, INC  
1600 MARKET ST, SUITE 520  
PHILADELPHIA, PA 19103  
267.256.0300

CITY OF PHILADELPHIA  
REBUILD PHILADELPHIA & PHILADELPHIA PARKS & RECREATION  
1515 ARCH STREET  
11TH FLOOR, ONE PARKWAY BUILDING  
PHILADELPHIA, PENNSYLVANIA

PROJECT TITLE  
MILES MACK BUILDING RENOVATION

DRAWING TITLE  
COVER SHEET

PROJECT NO. 10-20-XXXX-01	DRAWING NO. <b>G0.0</b>
DATE: 02.07.2020	
SCALE: AS NOTED	
DRAWN BY:	
CHECKED BY:	FILE:

NOTE: ALL DIMENSIONS AND CONDITIONS SHALL BE VERIFIED BY THE CONTRACTOR AT THE SITE BEFORE PROCEEDING WITH THE WORK.